for HOLDINGS.

10940 SW Barnes Road #364 Portland, Oregon 97225 503-201-7025 | 503-347-4685



3514 COMMERCIAL ST | SALEM, OR

CODE REVIEW 9,000 SF 3514 COMMERCIAL STREET SE, SALEM, OR 97302 OCCUPANCY LOAD EXITING CODES 23 OCCUPANTS 1 REQUIRED | 1 PROVIDED (ADA) 2019 OREGON STRUCTURAL SPECIALTY CODE 2 OCCUPANTS 1 REQUIRED | 1 PROVIDED (ADA) 2019 OREGON MECHANICAL SPECIALTY CODE 1 REQUIRED | 2 PROVIDED (ADA) 2021 OREGON PLUMBING SPECIALTY CODE 2021 OREGON ELECTRICAL SPECIALTY CODE MAXIMUM TRAVELDISTANCE 2019 OREGON ENERGY EFFICIENCY SPECIALTY CODE COMMON PATH: 75 FEET TRAVEL DISTANCE: ZONING JURISDICTION: CITY OF SALEM PLUMBING FIXTURE CALCULATIONS CODE: CITY OF SALEM REVISED CODE OCCUPANCY FACTOR AREA LOAD MEN / %WC / %LAV WOMEN / %WC / %LAV UNIFIED DEVELOPMENT CODE M (C-STORE) 60 1,335 sf 11.5 / 0.023 / 0.015 11.5 / 0.023 / 0.015 0.5 / 0.020 / 0.020 B (OFFICE) 150 0.5 / 0.020 / 0.020 CR (RETAIL COMMERCIAL) ZONING: B (STORAGE) 300 245 sf 0.5 / 0.005 / 0.005 0.5 / 0.005 / 0.005 TOTAL REQUIRED 083W03DB07300 TAX LOT PROVIDED 1.0 WC / 1.0 LAV (UNISEX) ADJACENT PLANNING DISTRICTS ZONES PARKING (RETAIL TRADE) CR (RETAIL COMMERCIAL) VEHICLE STALLS (4/1000 SF MIN.) ALL SIDES NONE REQUIRED 11 LOADING SPACE SETBACKS: 4 (NO COVER REQUIRED) **BICYCLE PARKING** FRONT NONE (BUILDING): 5 FEET MINIMUM BARRIER REMOVAL SUMMARY (ORS 447.241) (VEHICLE USE AREAS): 447.241 (4): IN CHOOSING WHICH ACCESSIBLE ELEMENTS TO PROVIDE UNDER THIS SECTION, NONE PRIORITY SHALL BE GIVEN TO THOSE ELEMENTS THAT WILL PROVIDE THE GREATEST ACCESS. (BUILDING): (VEHICLE USE AREAS): 5 FEET MINIMUM SELEMENTS SHALL BE PROVIDED IN THE FOLLOWING ORDER: **ACCOMODATION** NONE 1. PARKING ACCESSIBLE PARKING PROVIDED A11 SIDES | REAR: (BUILDING): BUILDING ENTRANCE IS ACCESSIBLE A0.0 | A2.1 5 FEET MINIMUM (2. ACCESSIBLE ENTRANCE (VEHICLE USE AREAS): 3. ACCESSIBLE ROUTE BUILDING ELEMENTS ARE ACCESSIBLE 32,670 S.F. | 0.75 ACRES 4. ACCESSIBLE RESTROOM(S) EXISTING UNISEX R.R. IS ACCESSIBLE SITE AREA ACCESSIBLE TELEPHONES NO PHONES IN CONTRACT N/A ACCESSIBLE DRINKING FOUNTAINS DRINKING FOUNTAINS NOT REQUIRED **BUILDING AREA** C-STORE: FOR THE OCCUPANCY SEE ITEM 3 ACCESSIBLE ELEMENTS SUCH AS STORAGE AND ALARMS OCCUPANCY GROUPS MERCANTILE (MARIJUANA DISPENSARY)

V-B **NON**-SPRINKLERED

GENERAL NOTES

SCOPE: THESE DRAWINGS ARE FOR TENANT IMPROVEMENT PERMIT ONLY.

- PERMIT PLANS: ONE SET OF THE APPROVED PLANS BEARING THE STAMPS OF THE JURISDICTION'S BUILDING DIVISION MUST BE MAINTAINED ON THE PROJECT SITE DURING CONSTRUCTION.
- DOCUMENTS: THE DOCUMENTS FOR THIS PROJECT INCLUDE THE DRAWINGS LISTED IN THE 'SHEET INDEX'. DEFERRED SUBMITTALS: ALL WORK LISTED UNDER DEFERRED SUBMITTALS WILL REQUIRE SEPARATE PERMIT.
- SUBMIT DRAWNGS FOR REVIEW BY ARCHITECT, CONTRACTOR, AND JURISDICTION. MODIFICATIONS: ANY MODIFICATIONS TO THE EXIST'G. BUILDING SYSTEMS, INCLUDING, BUT NOT LIMITED TO: ELECTRICAL, PLUMBING, MECHANICAL, FIRE SUPPRESSION, AND FIRE ALARM, SHALL BE PERFORMED UNDER BIDDER DESIGN FORMAT WITHIN GUIDELINES OF THESE CONSTRUCTION DOCUMENTS, AND SHALL MEET OR EXCEED ALL APPLICABLE CODES. IT SHALL BETHE GENERAL CONTRACTORS RESPONSIBILITY TO ENSURE THAT ALL PERMITS ARE OBTAINED AND AL. APPLICABLE CODE REQUIREMENTS AND REGULATIONS
- 6. ADA: THIS PROJECT SHALL COMPLY WITH ALL FEDERAL AND STATE ADA REQUIREMENTS, COMPLY WITH APPLICABLE REGULATIONS FOR BARRIER-FREE FACILITIES (O.S.S.C. CHAPTER 11) INCLUDING DOOR HARDWARE & DESIGN BUILD ITEMS.
- SAFETY: THE CONTRACTOR SHALL DESIGN, INSTALL, AND MAINTAIN ALL SAFETY DEVICES AND SHALL BE SOLELY RESPONSIBLE FOR CONFORMING TO ALL LOCAL, STATE AND FEDERAL SAFETY REGULATIONS. CODE COMPLIANCE: ALL MATERIALS AND WORKMANSHIP SHALL CONFORM WITH ALL STATE AND LOCAL JURISDICTIONAL BUILDING CODES / REGULATIONS.
- MAINTAIN STRUCTURAL AND FIRE RESISTIVE INTEGRITY OF EXISTING BUILDING.
- PRE-CONSTRUCTION: PRIOR TO BEGINNING WORK, THE GENERAL CONTRACTOR WILL FAMILIARIZE HIMSELF WITH THE PROPOSED WORK AREA, INCLUDING SITEWORK, WORK BY OTHERS, AND SURROUNDING AREAS. IDENTIFY ANY DISCREPANCIES BETWEEN THE DRAWINGS AND THE EXISTING CONDITIONS, AND NOTIFY THE OPENINGS: THE CONTRACTOR SHALL REVIEW PLANS TO VERIFY AND COORDINATE ALL OPENINGS AND
- ROUGH-OUTS THROUGH SLABS, WALLS, CEILINGS AND ROOFS. VERIFY ALL ROUGH-IN DIMENSIONS. 12. WOOD: ALL WOOD IN CONTACT WITH CONCRETE OR MASONRY SHALL BE PRESSURE TREATED. ALL FIRE TREATED WOOD/SHEATHING TO COMPLY WITH SECTION 2303.2, AND CARRY ALL REQUIRED LABELS FOR REVIEW BY BUILDING INSPECTOR.
- DRAWINGS: DO NOT SCALE DRAWINGS. THE CONTRACTOR SHALL USE DIMENSIONS SHOWN ON THE DRAWINGS AND ACTUAL FIELD MEASUREMENTS NOTIFY THE ARCHITECT IF ANY DISCREPANCIES ARE FOUND. LARGER SCALE DRAWINGS TAKE PRECEDENCE OVER SMALLER SCALED DRAWINGS. WHERE DISCREPANCIES OCCUR, REPORT TO ARCHITECT OR ENGINEER.
- DIMENSIONS: ALL DIMENSIONS TO FACE OF STUD UNLESS OTHERWISE NOTED. CONCRETE/ MASONRY DIMENSIONS ARE GIVEN TO FACE OF CONCRETE/MASONRY AND/OR TO THE EDGE OF CONCRETE SLABS.
- BLOCKING & SUPPORTS: PROVIDE SOLID BLK'G. & SUPPORTS FOR NEW CONSTRUCTION AS REQ'D. FOR COMPLETE ASSEMBLY. PROVIDE BLOCKING AT ALL PLYWOOD AND GYPSUM BOARD SHEATHING EDGES. REFER TO STRUCTURAL FOR NAILING INFORMATION. NEW TO EXIST'G.: AT PROPOSED WORK TO MATCH EXIST'G., PATCH & REPAIR EXIST'G, WORK IMPACTED BY
- CONSTRUCTION. PAINT & FINISH ENTIRE AFFECTED AREA TO INSIDE CORNER OR OTHER DEFINED EDGE WHEREVER WORK OCCURS. OPENINGS: ALL PERIMETER OPENINGS TO BE CAULKED, SEALED OR WEATHER-STRIPPED FOR
- WEATHER-TIGHT ASSEMBLY. ALL FLASHING AND ARCHITECTURAL SHEET METAL TO BE MINIMUM 24 GA. GALVANIZED STEEL, FACTORY PRIMED AND FIELD PAINTED. 10'-0" LENGTHS, PER SMACNA MANUAL UNLESS BUILDING OTHERWISE NOTED. AS REQUIRED TO RESULT IN A FULLY WEATHERTIGHT ASSEMBLY. 18. VAPOR BARRIERS: CONTINUOUS APPROVED VAPOR BARRIERS SHALL BE INSTALLED ON THE HEATED SIDE OF ALL THERMAL INSULATION INSTALLED.
- 19. FIRE EXTINGUISHERS: PROVIDE FIRE EXTINGUISHERS WITH REQUIRED SIGNAGE AS REQ'D. BY FIRE DEPARTMENT FIELD INSPECTOR. DURING CONSTRUCTION, PROVIDE A PORTABLE FIRE EXTINGUISHER WITH TYPE A,B,C RATING WITHIN 75 FOOT DISTANCE TO ALL PORTIONS OF THE BUILDING.

DIRECTORY

OWNER JJS HOLDINGS, LLC 18066 NE AIRPORT WAY PORTLAND, OREGON 97320 CONTACT: JUSTIN LABHART p: 916-507-2485

p: 503-347-4685 e: ssutton@sg-arch.net e: j.labhart@jjs.holdings CONTACT: KEVIN GODWIN p: 503-201-0725 e: kgodwin@sg-arch.net

CONTACT: SCOT SUTTON

5247 NE 49TH AVE, PORTLAND, OR 97218

p: 503.757.2611

e: andrew@arris-consulting.com

e: info@mecengineering.net

WATER | SEWER

555 LIBERTY STREET SE

PUBLIC WORKS

SALEM, OR 97301

503-588-6311

CITY OF SALEM

CONTACT: ANDREW CRAIG

MECHANICAL

STRUCTURAL JAMES G PIERSON CONSULTING ENGINEERS, INC. ARRIS CONSULTING, LLC 610 SW ALDER, SUITE 918 PORTLAND, OR 97205 CONTACT: TONYA HALOG o: 503-226-1286

e:tonya@jgpierson.com CONTACT: PEDER GOLBERG p: 503-226-1286 e: peder@jgpierson.com

p: 503-843-8233

ELECTRICAL COMMERCIAL PLUMBING CONSULTING & DESIGN MEC ENGINEERING 18859 \$W MARTINAZZI AVE., TUALATIN, OR 97062 CONTACT: MAJID HABIBI, PE CONTACT: SHANE FITZPATRICK p: 503-860-4507

JURISDICTIONAL OFFICES

e: www.commercialplumbingdesign.com

PLANNING ZONING & LAND USE CITY OF SALEM 555 LIBERTY STREET SE **ROOM 305** SALEM, OR 97301

503-588-6213

SALEM, OR 97301

503-588-6256

NW NATURAL 220 NW 2ND AVE. PORTLAND, OREGON 97209 503-226-4211

GAS

PERMIT APPLICATION CENTER PORTLAND GENERAL ELECTRIC CITY OF SALEM 121 SW SALMON STREET 555 LIBERTY STREET SE PORTLAND, OR 97204 ROOM 320 503-228-6322

ARCHITECT SG ARCHITECTURE, LLC. 10940 SW BARNES RD. #364 PORTLAND, OREGON 97225

PROJECT DESCRIPTION APPROX. 2,092 SF OF INTERIOR TENANT IMPROVEMENTS FOR JJS HOLDINGS, LLC. THE PROPOSED TENANT IMPROVEMENT WILL REPLACE AN EXISTING CONVENIENCE STORE AND COFFEE SHOP LOCATED IN AN EXISTING SINGLE STORY BUILDING OF STUCCO ON FRAME CONSTRUCTION. IMPROVEMENTS INCLUDE A NEW SALES AREA, OFFICE, IT ROOM, & STOCKROOM. AN EXISTING UNISEX RESTROOM WILL BE LIGHTLY REMODELED TO ADD A VERTICAL GRAB BAR TO MEET ADA REQUIREMENTS. SITEWORK IS LIMITED TO RE-CONFIGURING/ADDING PARKING STALLS WITHIN EXISTING CURB LINE. GASOLINE PUMPS AND CANOPY PREVIOUSLY ON THE SITE HAVE BEEN REMOVED BY OTHERS.

DESIGN BUILD | DEFERRED SUBMITTALS

- NO DEFERRED SUBMITTALS WITH THIS APPLICATION.
- MECHANICAL, ELECTRICAL, AND FIRE ALARM PERMITS WILL BE SEPARATE APPLICATIONS. THERE IS NO PLUMBING WORK IN THE SCOPE OF WORK, EXCEPT FOR DEMOLITION - NO PLUMBING PERMIT NEEDED.
- 4. BUILDING DOES NOT HAVE A FIRE SPRINKLER SYSTEM

SHEET INDEX

A0.0 COVERSHEET, CODE REVIEW & GENERAL INFORMATION A0.1 SPECIFICATION NOTES A0.2 SPECIFICATION NOTES A 1.0 EXISTING CONDITIONS PLAN (ALTA SURVEY - FOR REFERENCE ONLY) A1.1 SITE PLAN AND PARKING SUMMARY A1.2 SITE DETAILS A1.3 EROSION CONTROL PLAN | EXISTING LANDSCAPE SURVEY A1.4 EROSION CONTROL DETAILS SP1.0 SITE PHOTOMETRIC PLAN

A2.1 DEMO, FLOOR, & CEILING PLANS | SCHEDULES | DETAILS


ADA1 ADA GUIDELINES (REFERENCE ONLY) ADA2 ADA GUIDELINES (REFERENCE ONLY)

D-1 DEMOLITION PLAN A1.5 CLASS 3 ADJUSTMENT - SITE PLAN

SCALE: 3/32" = 1'-0" VICINITY MAP

CLASS 2

SITE PLAN REVIEW & INTERIOR TENANT **IMPROVEMENT** DRAWINGS for

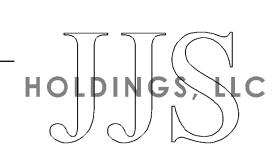


JJS HOLDINGS, LLC 18066 NE AIRPORT WAY PORTLAND, OREGON 97320

SITE & INTERIOR TENANT IMPROVEMENTS LOCATED AT THE **EXISTING CHEVRON FOOD MART**

3514 COMMERCIAL STREET SE SALEM, OR 97302

CODE PLAN

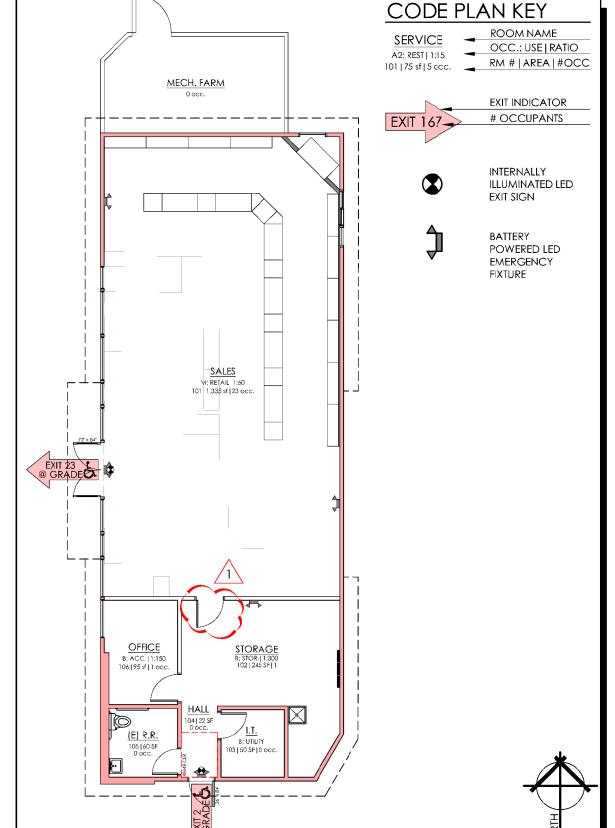



ISSUED FOR PERMIT

LIABLE FOR ANY CHANGES, REVISION THIS DOCUMENT AND ACTUAL FIELD PURSUANT TO A LEASE OR LEASE.

CCURACY AND DOES NOT CONSTITUTE A **GUARANTY OR ASSURANCE OF THE** MENSIONS, LAYOUT, SIZES, CAPACITY C MODIFICATIONS TO SAME.

PROJECT NUMBER: 21-105

ISSUE DATE: MARCH 20, 2022

DRAWN BY: KG & SS

Revisions:

09.30.2021 (B/S & Planning) Responses #01 (21-11571RP | 21-115194 BP)

03.20.2022 (Planning) CLASS 3 ADJUSTMENT

COVER SHEET **CODE REVIEW**

CONSTRUCTION TYPE

ALLOWABLE AREAS BY OCCUPANCY GROUP